


ITEM 2.4 - FLOW DIAGRAM

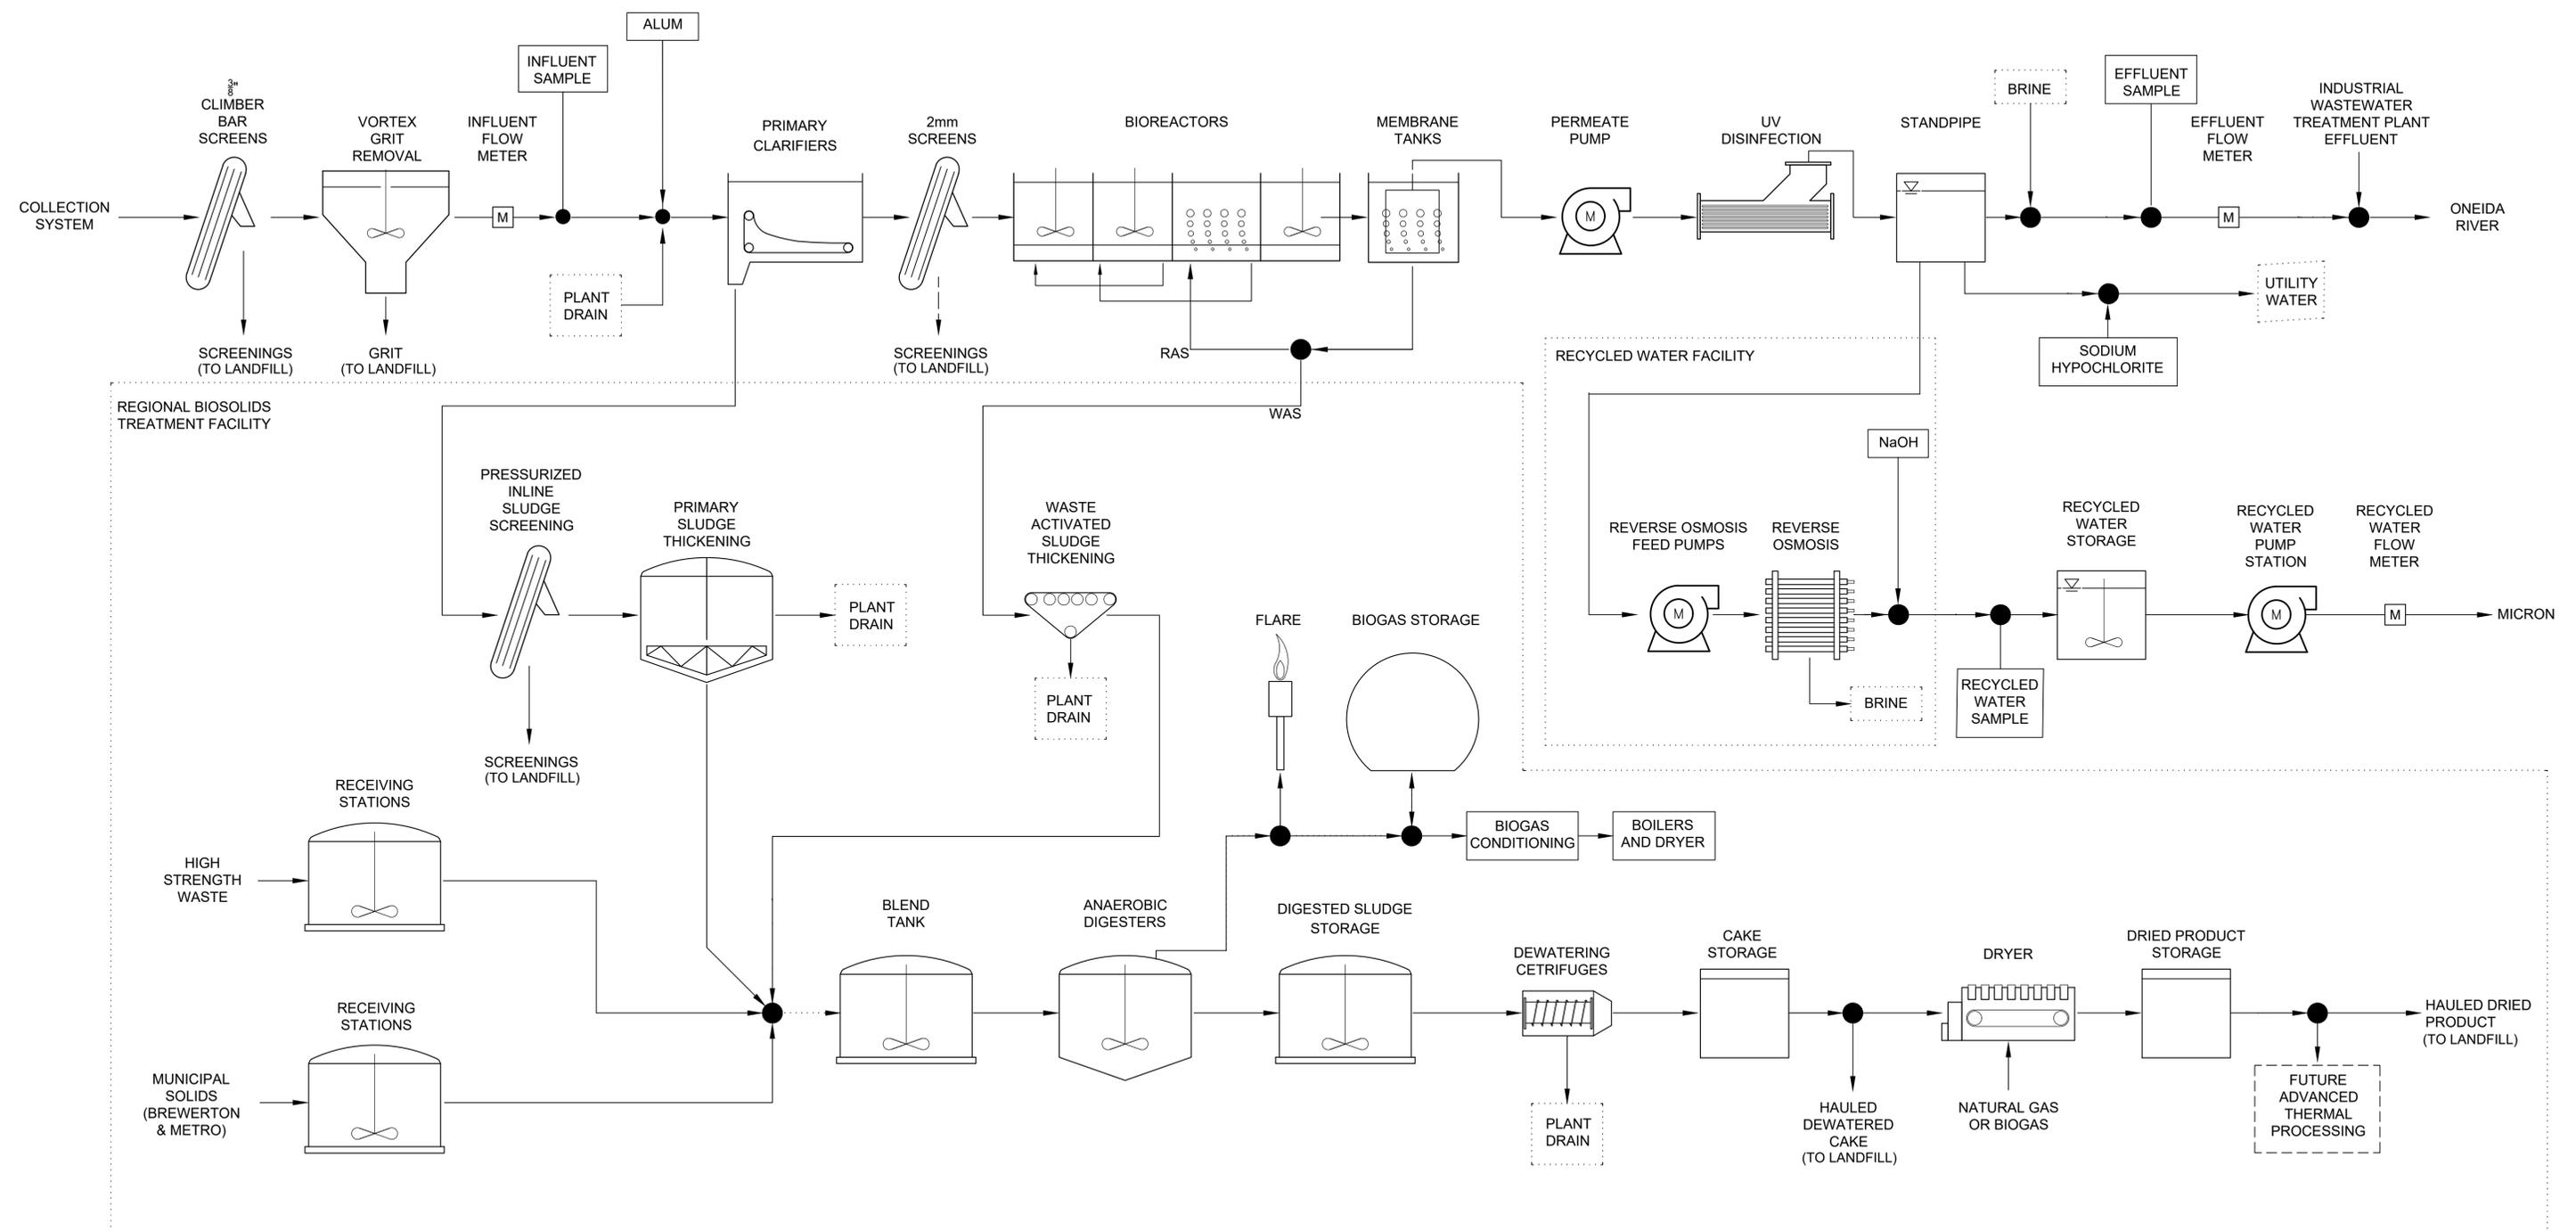

LAST SAVED BY:

25% DESIGN SUBMITTAL
NOT FOR CONSTRUCTION

DESIGNED
CE
DRAWN
CE
CHECKED
DATE
JUNE 2025



ONONDAGA COUNTY DEPARTMENT OF WATER
ENVIRONMENT PROTECTION
OOWWTP EXPANSION PROGRAM - UPGRADES AND BIOSOLIDS FACILITY
GENERAL
PROCESS FLOW DIAGRAM

VERIFY SCALES
BAR IS ONE INCH ON ORIGINAL DRAWING
0 1"
IF NOT ONE INCH ON THIS SHEET, ADJUST SCALES ACCORDINGLY

JOB NO.
203580-60000
DRAWING NO.
00G09
SHEET NO.
02 OF XX